



1 SOUTH ELEVATION  
1:250

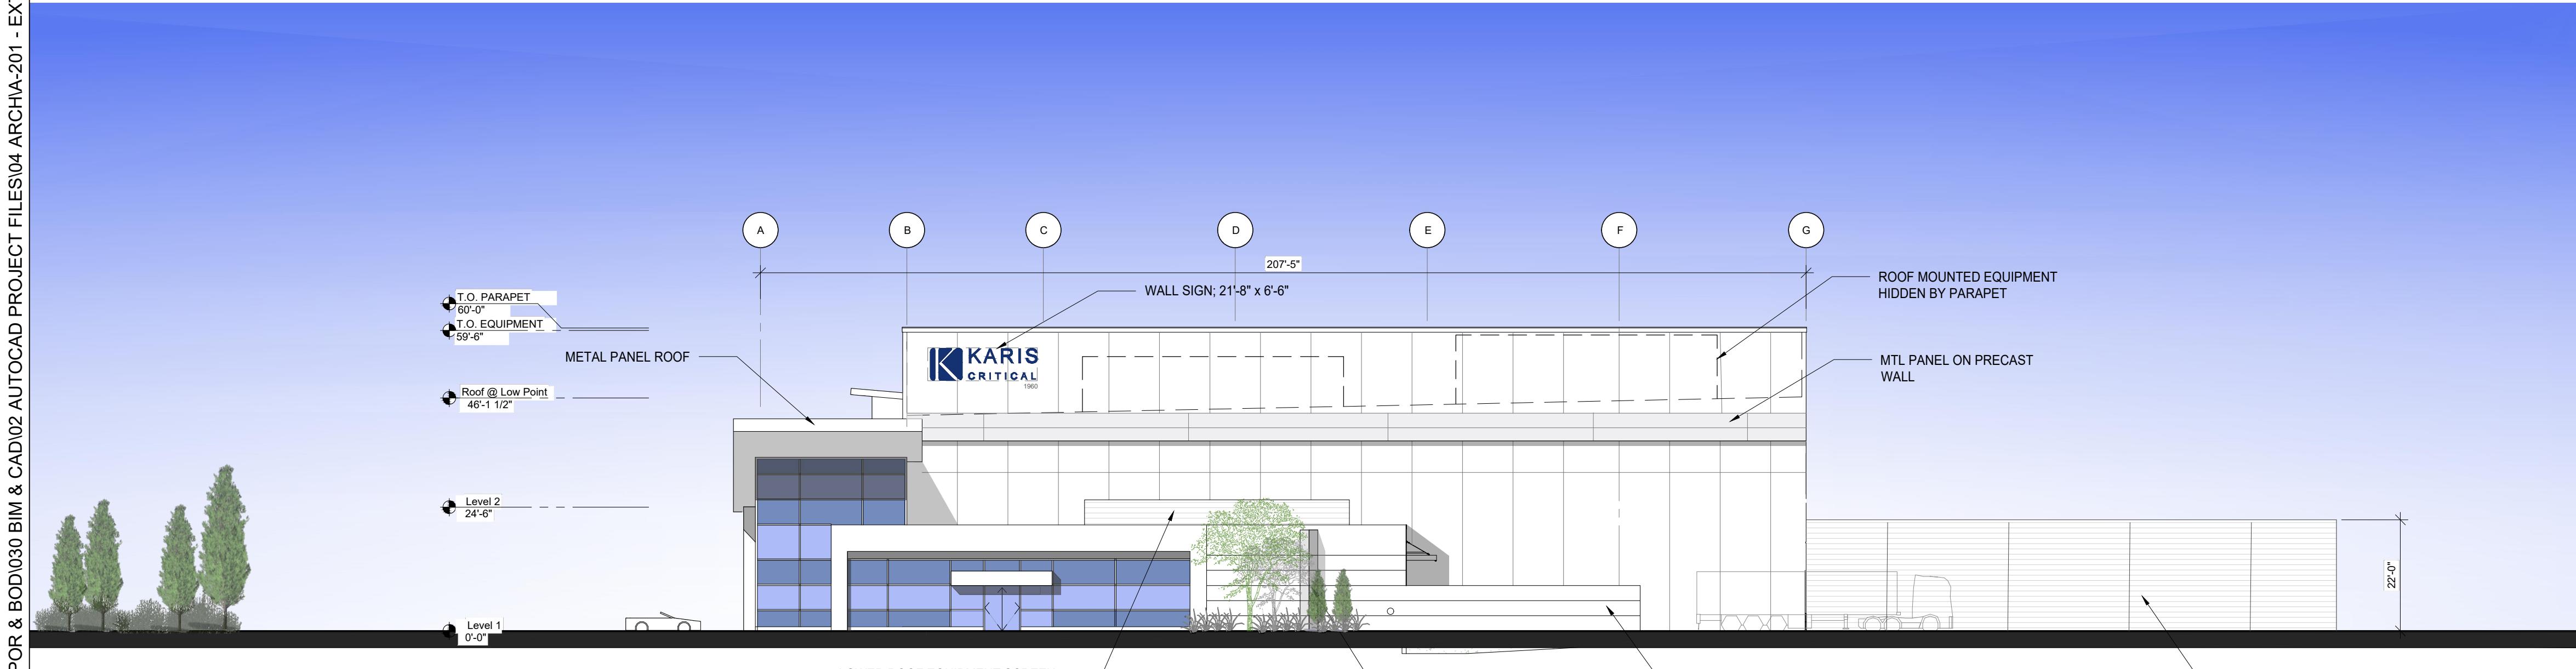


2 EAST ELEVATION  
1:250

CHKD BY	APPV'D BY	DESCRIPTION	ISSUANCE
YH	GT	ELEVATION CONCEPTUAL DESIGN - REV 4	09/26/25
YH	GT	ELEVATION CONCEPTUAL DESIGN - REV 3	07/23/25
YH	GT	ELEVATION CONCEPTUAL DESIGN - REV 2	06/11/25
YH	GT	ELEVATION CONCEPTUAL DESIGN - REV 1	04/14/25
YH	GT	ELEVATION CONCEPTUAL DESIGN	04/08/25

 <b>CARLSON</b> <small>Design Group</small> <small>Carlson Architectural Services of America</small> <small>Carlson Engineering Services of America</small> <small>5559 Peachtree Parkway, Suite 125</small> <small>Perimeter Center, GA 30092</small> <small>CarlsonDesignGroup.com</small> <small>Tel: 313.963.6300</small>	 <b>KARIS</b> <small>Critical</small> <small>KARIS MISSION CRITICAL, LLC</small>	<b>NOT FOR CONSTRUCTION</b>	
		PROJECT TITLE	KARIS NAPERVILLE DATA CENTER 1960 W LUCENT LANE NAPERVILLE, IL
		SHEET TITLE	EXTERIOR ELEVATIONS
PROJECT NUMBER	SHEET NUMBER	250194	A-201

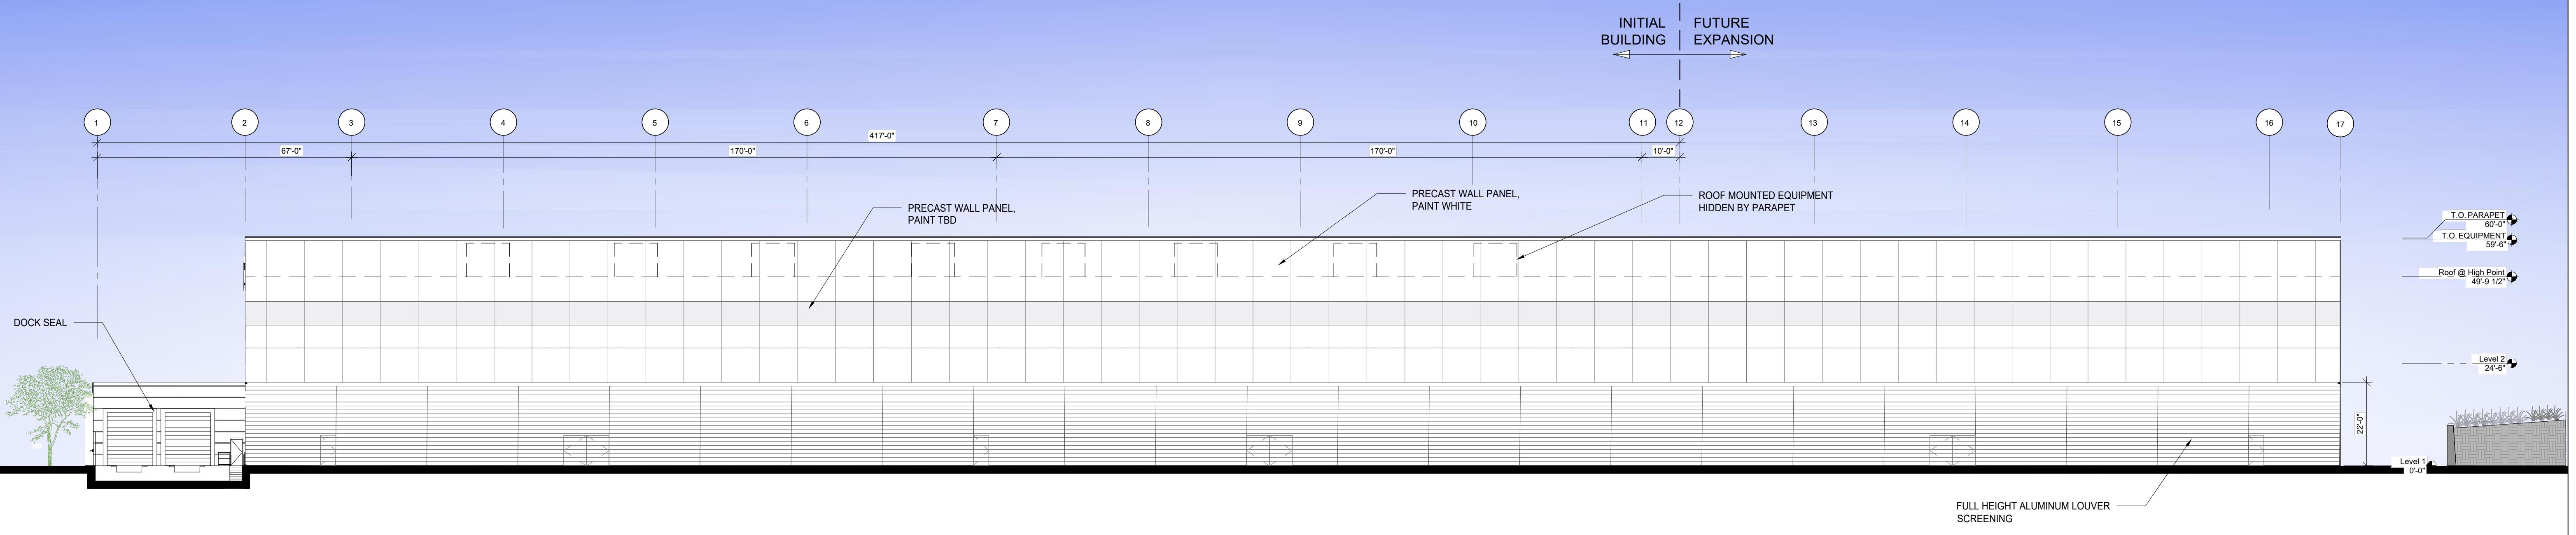

1 NORTH ELEVATION  
1:250

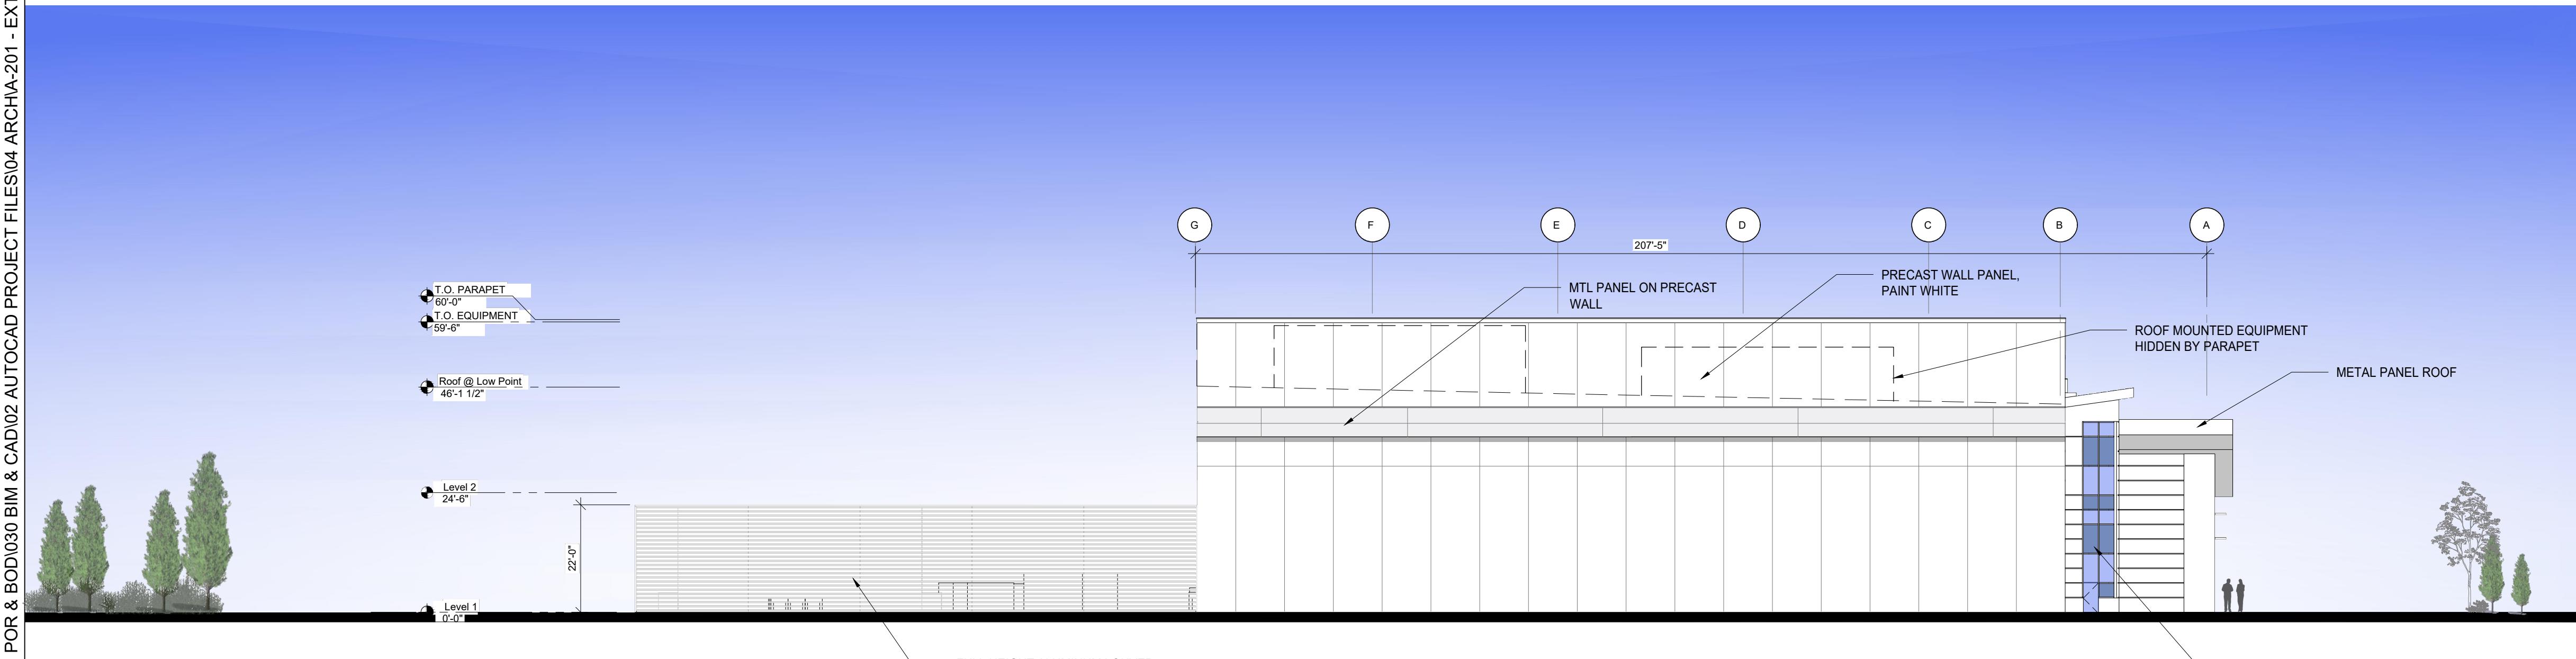


2 WEST ELEVATION  
1:250

CHKD BY	APPV'D BY	DESCRIPTION	ISSUANCE
YH	GT	ELEVATION CONCEPTUAL DESIGN - REV 4	09/26/25
YH	GT	ELEVATION CONCEPTUAL DESIGN - REV 3	07/23/25
YH	GT	ELEVATION CONCEPTUAL DESIGN - REV 2	06/11/25
YH	GT	ELEVATION CONCEPTUAL DESIGN - REV 1	04/14/25
YH	GT	ELEVATION CONCEPTUAL DESIGN	04/08/25

 <b>CARLSON</b> <small>Design Group</small> <small>Carlson Architectural Services of America</small> <small>Carlson Engineering Services of America</small> <small>5559 Peachtree Parkway, Suite 125</small> <small>Perimeter Center, GA 30092</small> <small>CarlsonGroup.com</small> <small>Tel: 313.963.6900</small>	 <b>KARIS</b> <small>Critical</small> <small>KARIS MISSION CRITICAL, LLC</small>	<b>NOT FOR CONSTRUCTION</b>	
		PROJECT TITLE	KARIS NAPERVILLE DATA CENTER 1960 W LUCENT LANE NAPERVILLE, IL
		SHEET TITLE	EXTERIOR ELEVATIONS
PROJECT NUMBER	SHEET NUMBER	250194	A-202



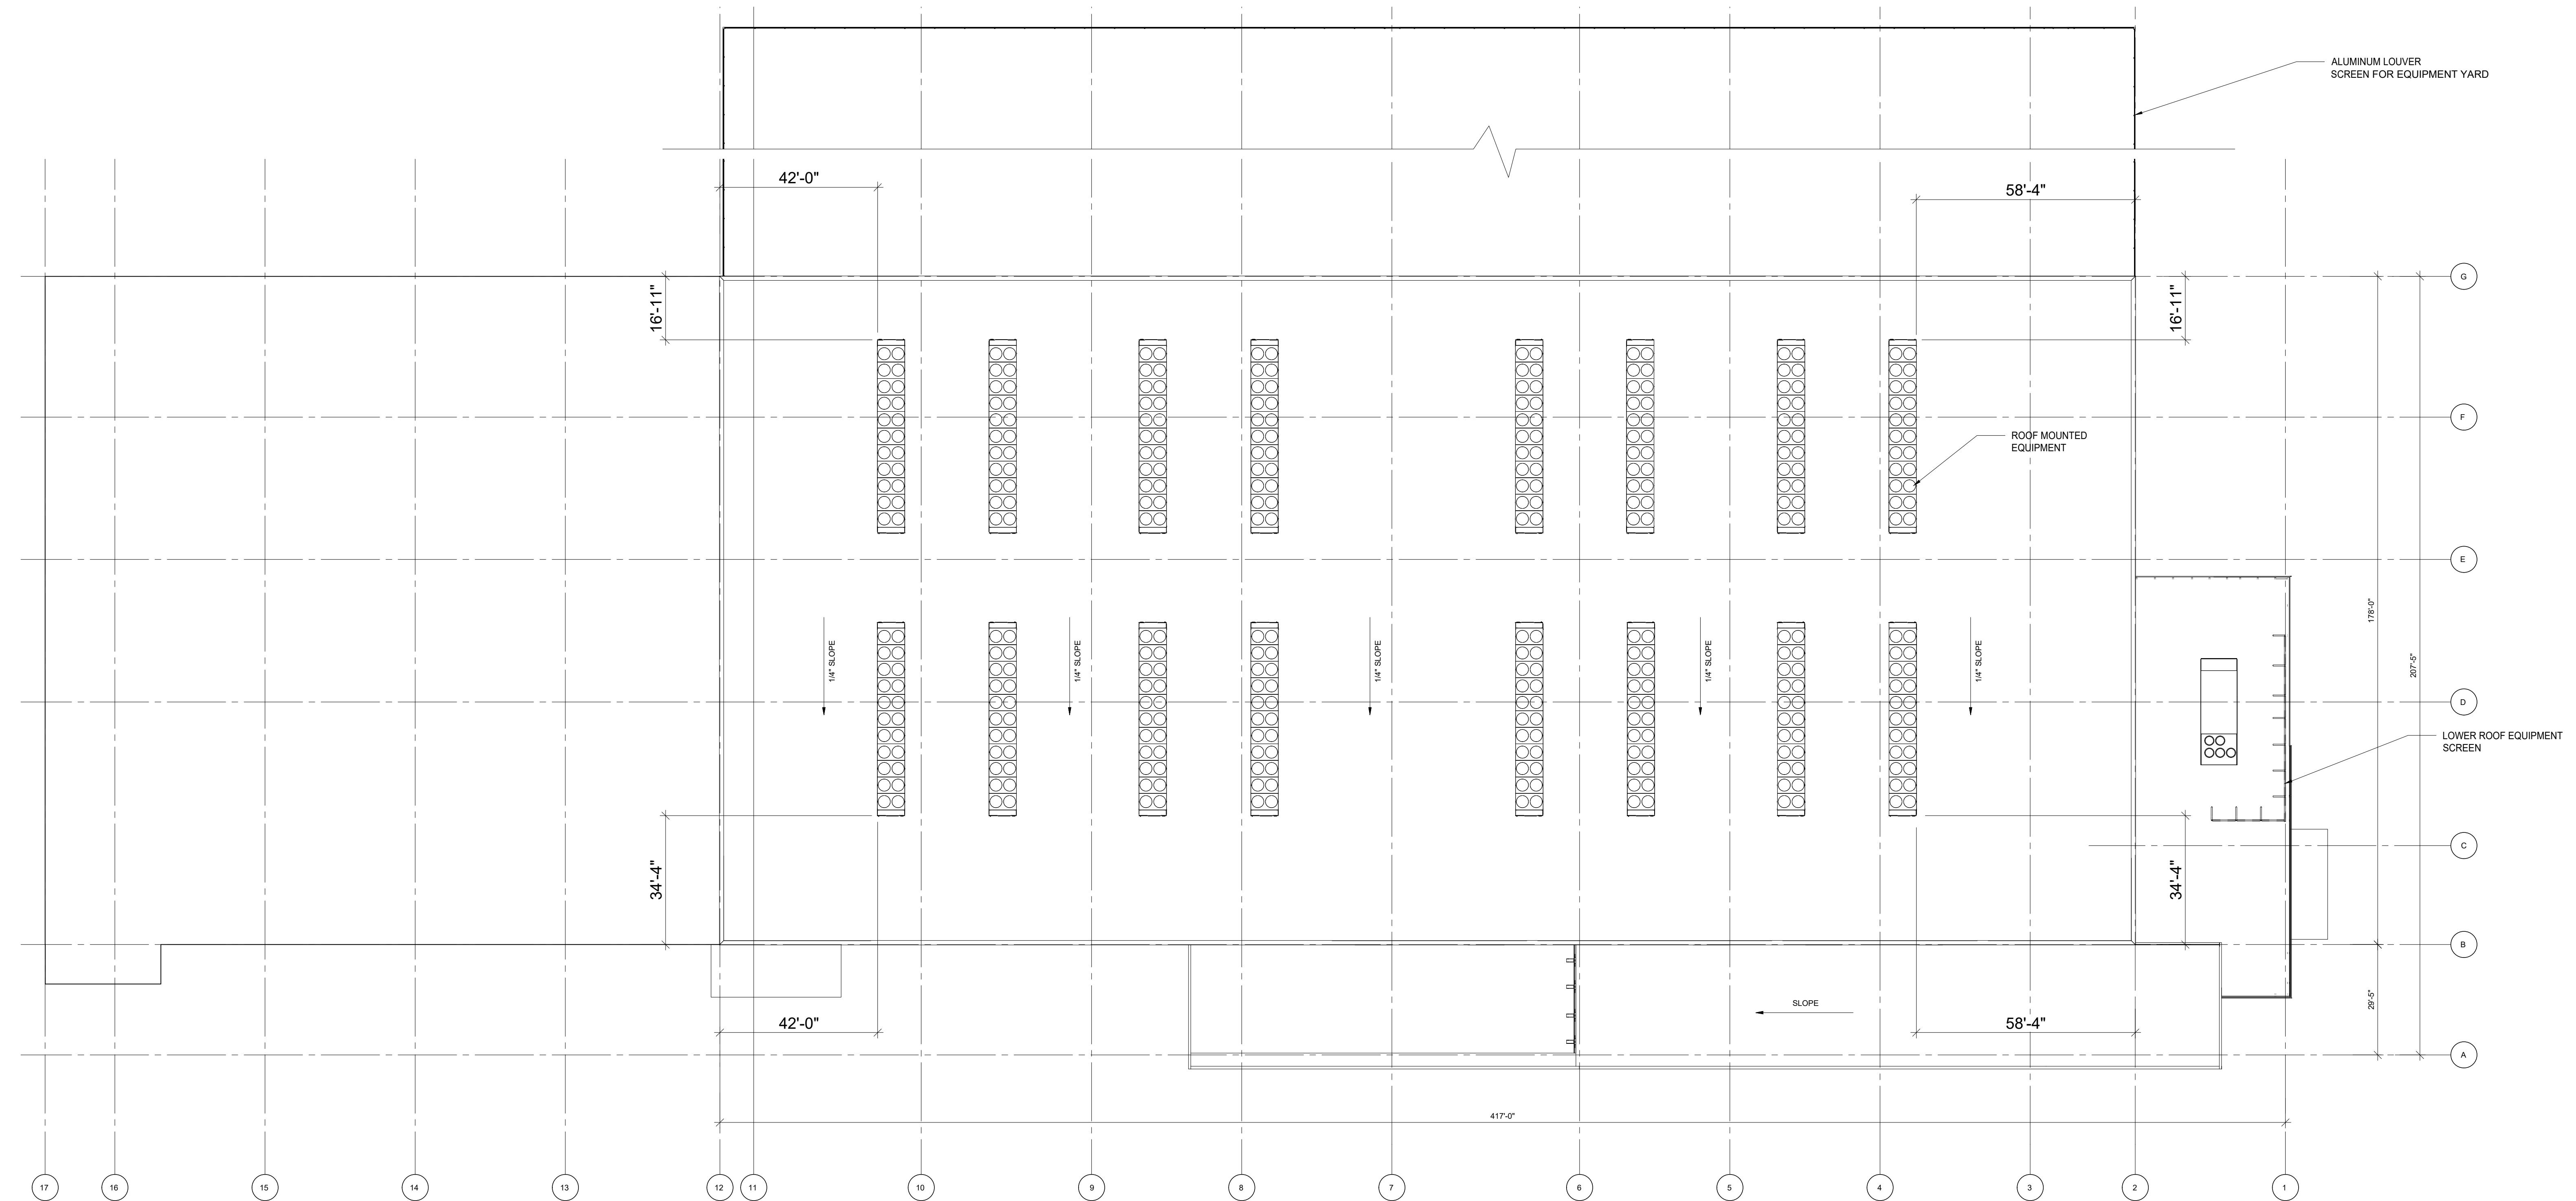

N

NOT FOR CONSTRUCTION

YH	GT	ELEVATION CONCEPTUAL DESIGN - REV 4	09/26/25
CHKD BY	APPV'D BY	DESCRIPTION	DATE
ISSUANCE			
CARLSON Design Group			
Carlson Architectural Services of America Carlson Engineering Services of America 5550 Peachtree Parkway, Suite 125 Peachtree Corners, GA 30092 CarlsonGroup.com Tel: 313.953.6300	KARIS	KARIS MISSION CRITICAL, LLC	
PROJECT TITLE	KARIS NAPERVILLE DATA CENTER 1960 W LUCENT LANE NAPERVILLE, IL		
SHEET TITLE	ROOF PLAN		
PROJECT NUMBER	250194	SHEET NUMBER	A-204